




NKBA STUDY GUIDE: SMALL KITCHEN

design by:

Dauida Rodriguez - Dauida's Kitchen and Tiles

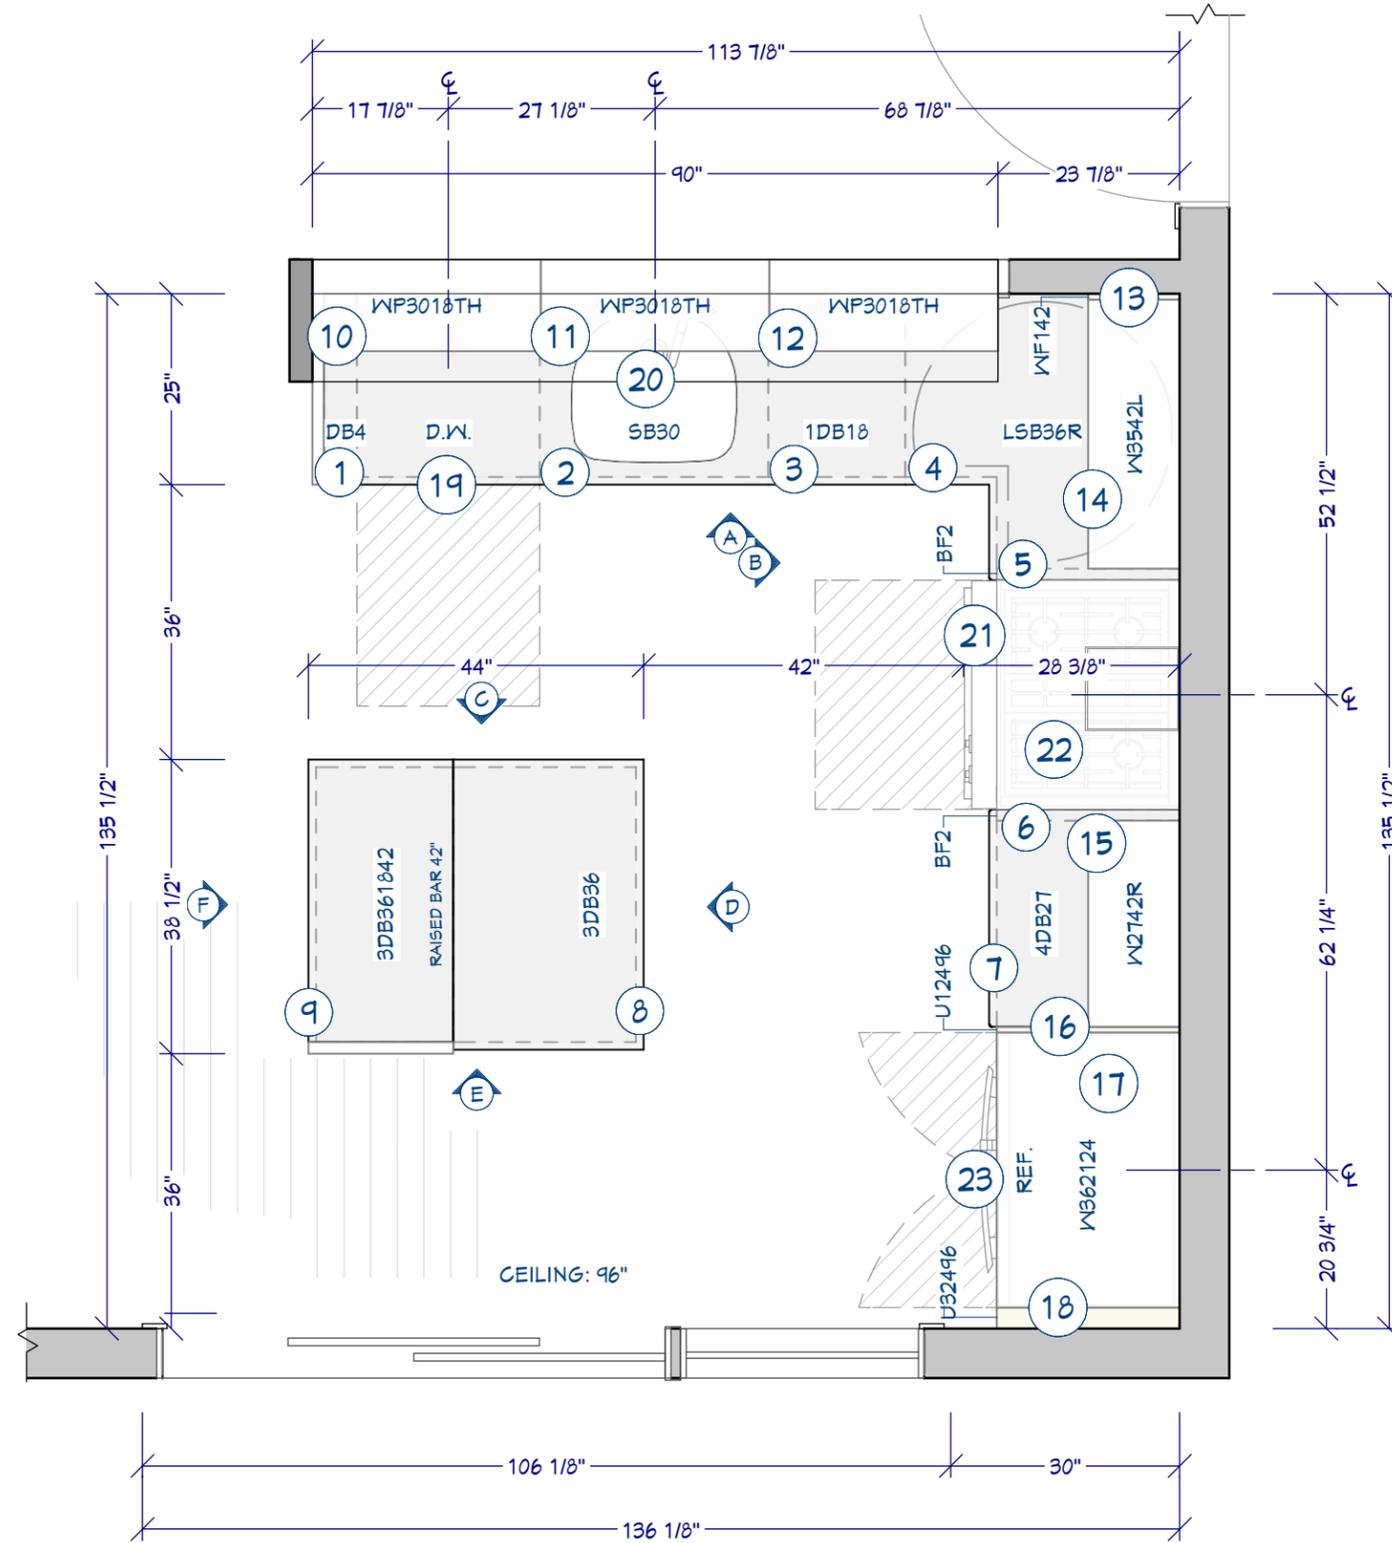

FLOOR PLAN SPECIFICATION:

- ① SPICE PANTRY PRESSURE LATCH
- ② SINK BASE W/ BOTTOM MAT
- ③ PULL-OUT DOUBLE TRASH
- ④ LAZY SUSAN
- ⑤ BASE FILLER CUT TO FIT
- ⑥ BASE FILLER CUT TO FIT
- ⑦ FULL EXTENSION DRAWER SLIDES
- ⑧ FULL EXTENSION DRAWER SLIDES
- ⑨ FULL EXTENSION DRAWER SLIDES
- ⑩ LIFT-UP DOOR
- ⑪ LIFT-UP DOOR
- ⑫ LIFT UP DOOR
- ⑬ WALL FILLER CUT TO FIT
- ⑭ BI-FOLD DOORS ON RIGHT/CENTER W/ 2 ADJUSTABLE SHELVES
- ⑮ BI-FOLD DOORS LEFT W/ 2 ADJUSTABLE SHELVES
- ⑯ 3/4" PARTITION
- ⑰ 1 ADJUSTABLE SHELF
- ⑱ FULL HEIGHT FILLER CUT TO FIT
- ⑲ PANEL FRONT DISHWASHER BRAND ABC; MDL. 123
- ⑳ SINK BRAND ABC; MDL. 123; FAUCET BRAND ABC; MDL. 234
- ㉑ RANGE 30"W BRAND ABC; MDL. 234
- ㉒ VENT HOOD BRAND ABC; MDL. 345
- ㉓ REFRIGERATOR 36"W BRAND ABC; MDL. 123

FLOOR PLAN

1/2" = 1'

DRAWINGS PROVIDED BY: ams
Chief Architect Software
chiefarchitect.com
800.292.3400


DESIGNER:
 Davida Rodrigues
 Davida's Kitchen and Tiles

PROJECT DESCRIPTION:
 NKBA Study Guide:
 Small Kitchen

SHEET TITLE:
FLOOR PLAN

| | |
|--------------------|--------------------|
| SCALE: SEE VIEW | DATE: 7/14/2017 |
|--------------------|--------------------|

K-1

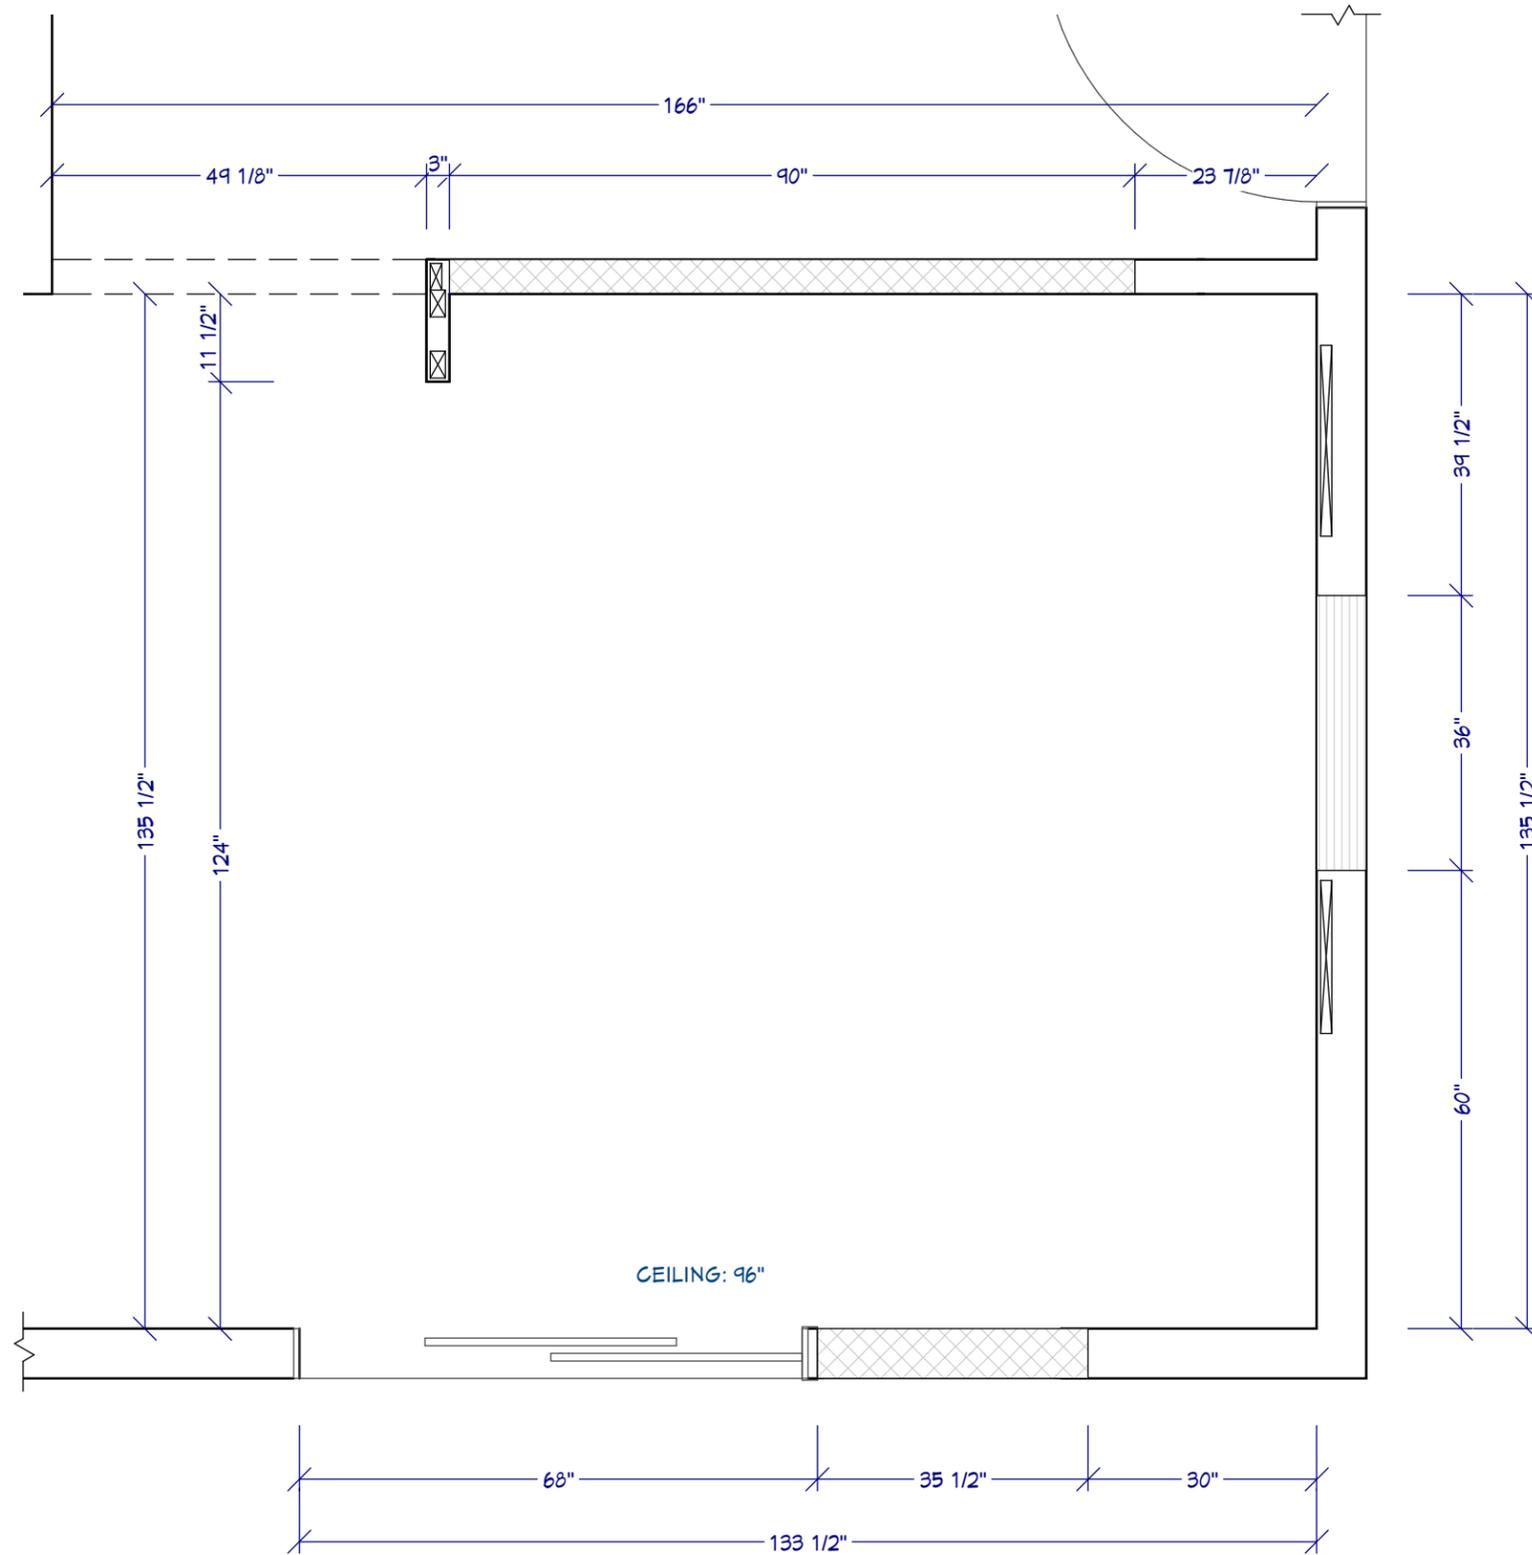

CONSTRUCTION LEGEND

- EXISTING WALL TO REMAIN
- EXISTING WALL TO BE REMOVED
- EXISTING OPENING TO BE CLOSED
- NEW WALL TO BE ADDED
- NEW OPENING TO BE ADDED
- BLOCKING FOR WALL CABINETS

CONSTRUCTION PLAN

1/2" = 1'

DRAWINGS PROVIDED BY: ams
 Chief Architect Software
 chiefarchitect.com
 800.292.3400

DESIGNER:
 Davida Rodrigues
 Davida's Kitchen and Tiles


PROJECT DESCRIPTION:
 NKBA Study Guide:
 Small Kitchen

SHEET TITLE:
CONSTRUCTION PLAN

SCALE:
 SEE VIEW

DATE:
 7/14/2017

K-2

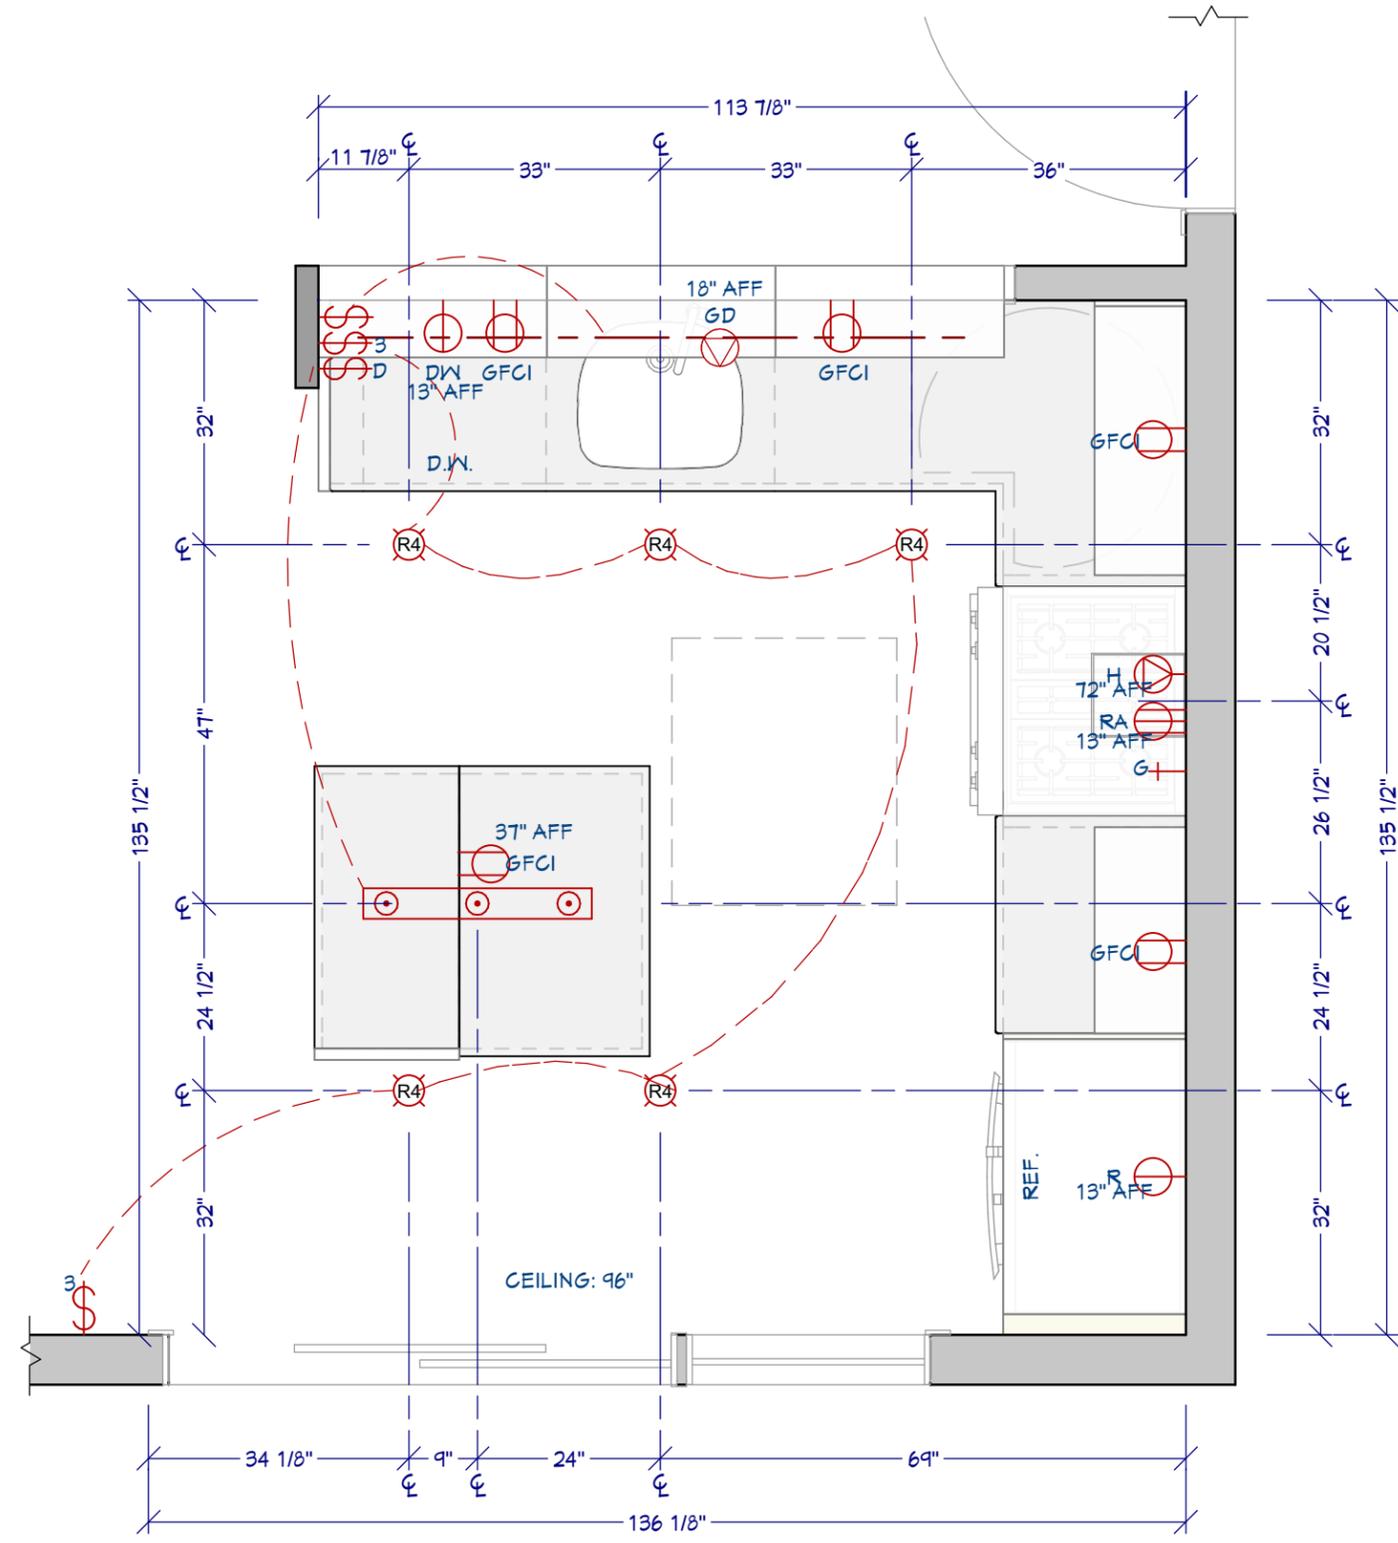

MECHANICAL LEGEND:



-  4" RECESSED L.E.D. LIGHT BRAND ABC; MDL. 123
-  TRIPLE PENDANT HALOGEN LIGHT BRAND ABC; MDL. 123
-  UNDER CABINET L.E.D. STRIP LIGHTING W/ INTEGRATED TRANSFORMER BRAND ABC; MDL. 123
-  SKYLIGHT
-  24" DISHWASHER BRAND ABC; MDL. 123; 120V
-  BATCH FEED GARBAGE DISPOSAL BRAND ABC; MDL. 123; 120V
-  30" VENT HOOD EXHAUST BRAND ABC; MDL. 123; 600CFM, 120V
-  30" ELECTRIC RANGE W/ GAS COOKTOP BRAND ABC; MDL. 123; 240V
-  GAS LINE
-  36" FRENCH DOOR REFRIGERATOR BRAND ABC; MDL. 123; 120V
-  GROUND FAULT CIRCUIT INTERRUPTER (GFCI); 120V
-  SINGLE POLE SWITCH
-  SINGLE POLE DIMMER SWITCH
-  3-WAY SWITCH


*ALL SWITCHES AND RECEPTACLES 48" ABOVE FINISHED FLOOR (AFF) UNLESS NOTED

MECHANICAL PLAN



1/2" = 1'

| | | | | | | | |
|---|--|---|--|---------------------------------|--------------------|--------------------|-----|
|  | DRAWINGS PROVIDED BY: ams Chief Architect Software chiefarchitect.com 800.292.3400 | DESIGNER: Davida Rodrigues Davida's Kitchen and Tiles | PROJECT DESCRIPTION: NKBA Study Guide: Small Kitchen | SHEET TITLE: MECHANICAL PLAN | SCALE: SEE VIEW | DATE: 7/14/2017 | K-3 |
|---|--|---|--|---------------------------------|--------------------|--------------------|-----|

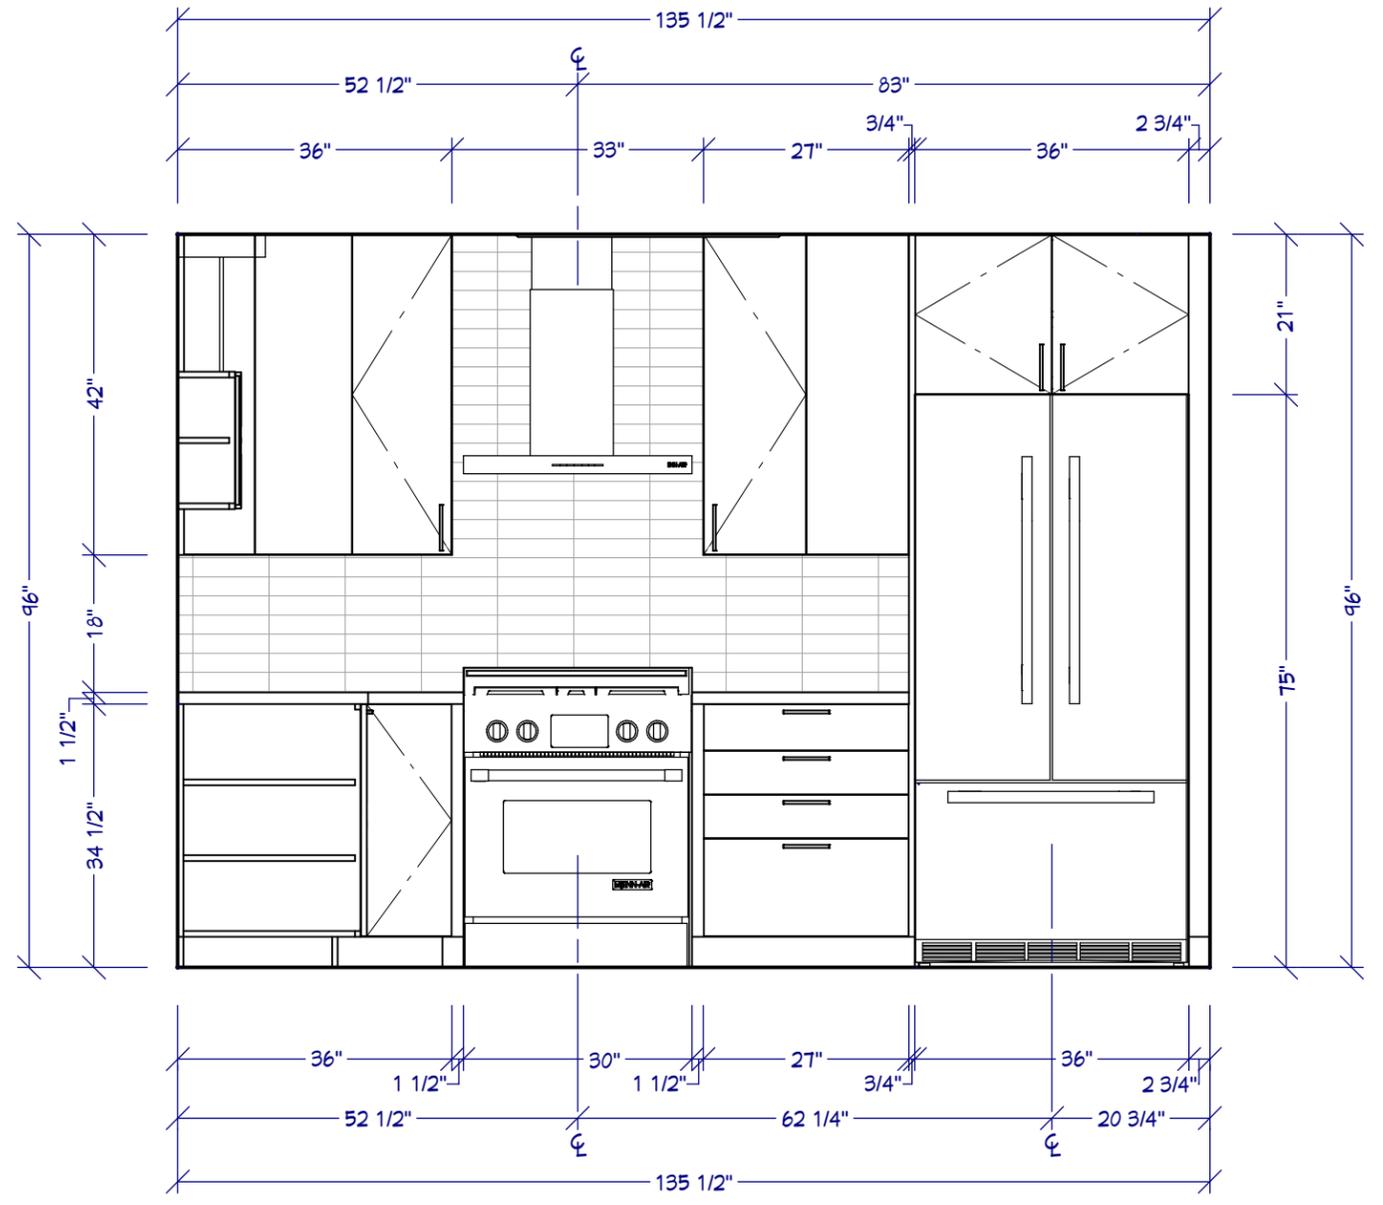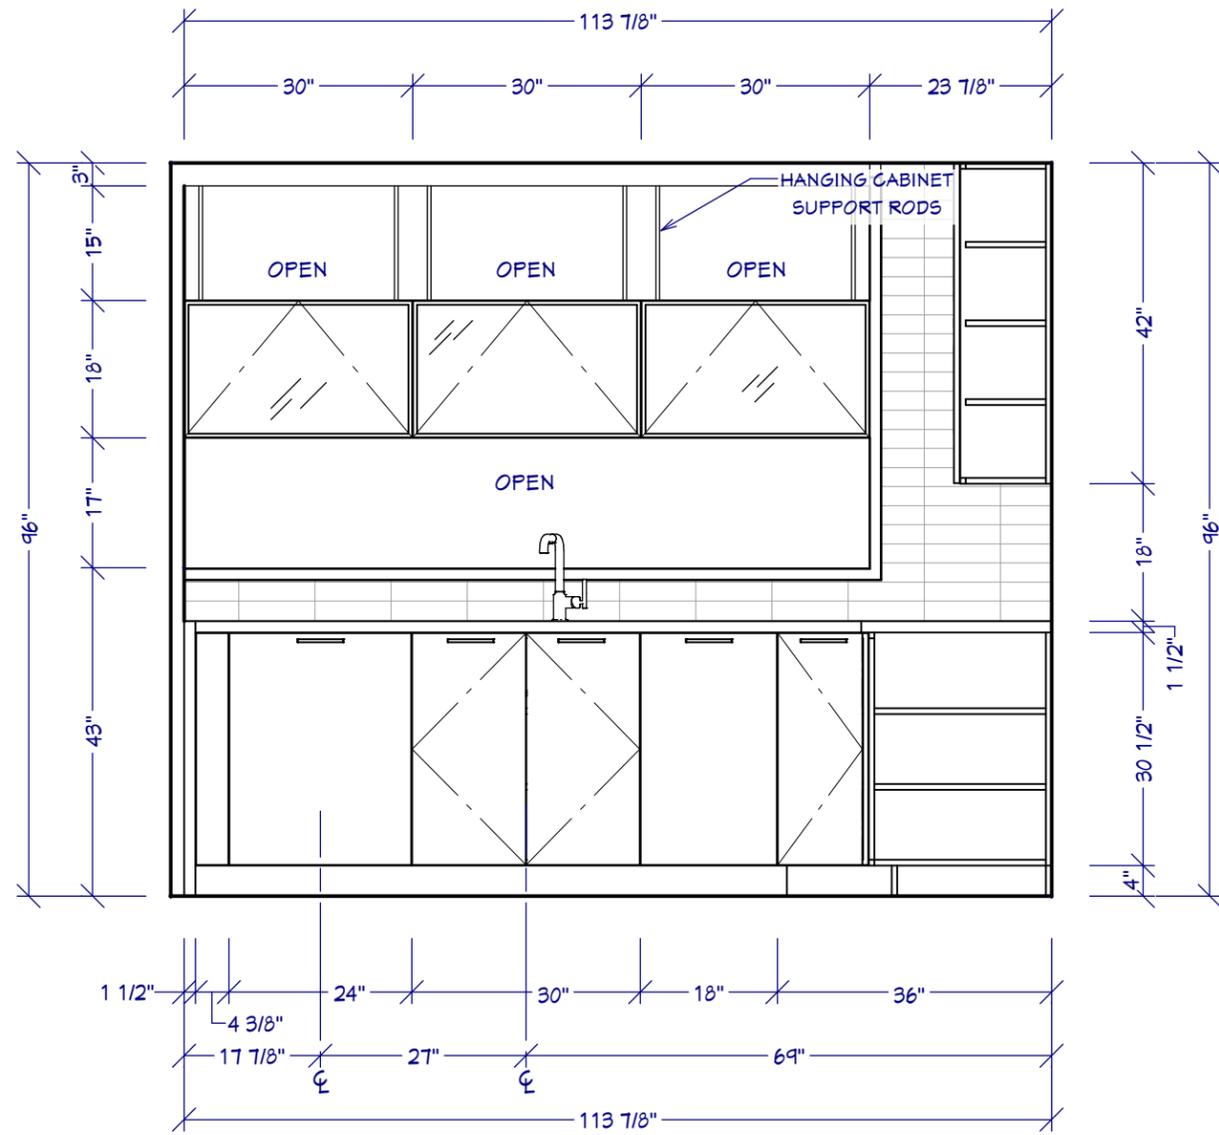


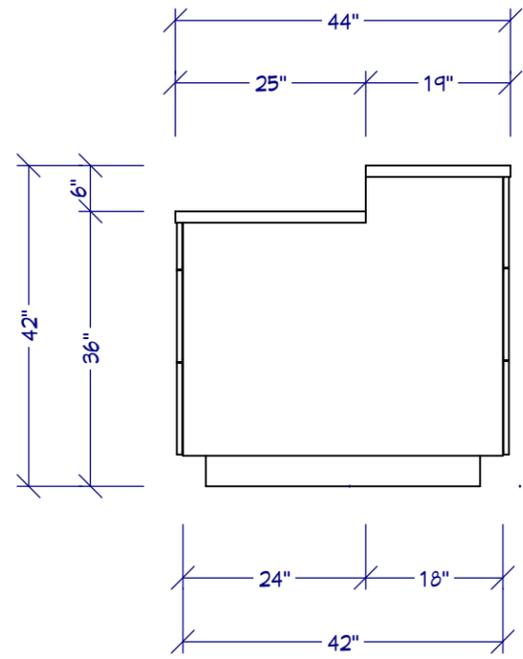


C ELEVATION C
1/2" = 1'

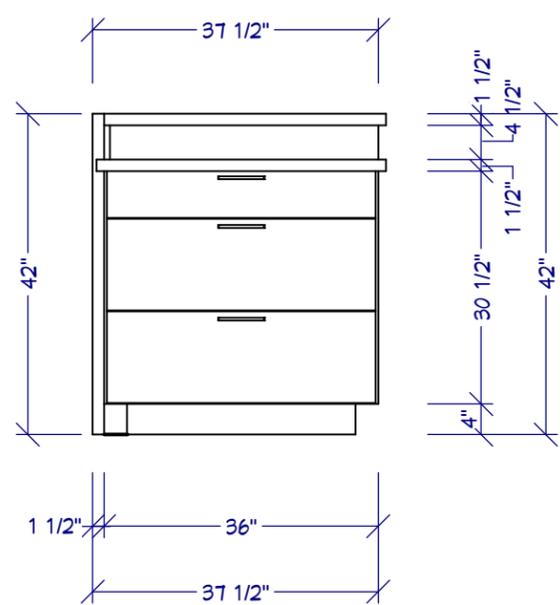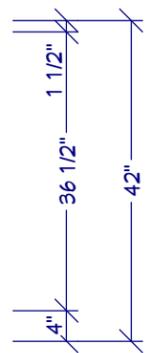

D ELEVATION D
1/2" = 1'

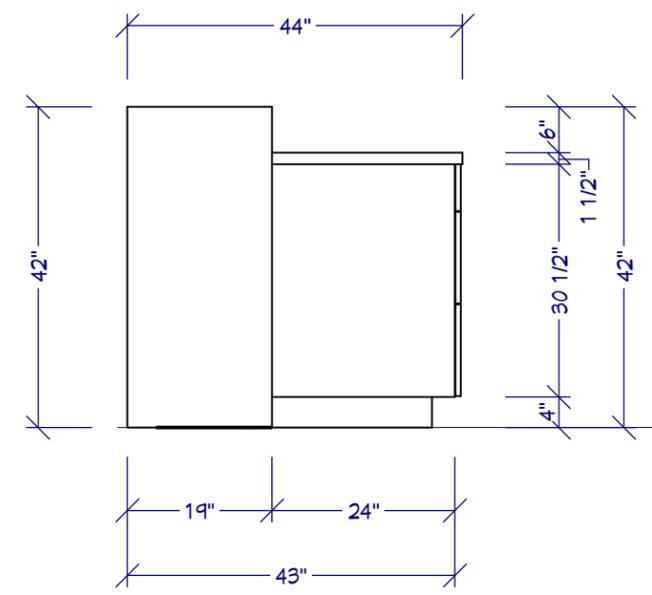

E ELEVATION E
1/2" = 1'

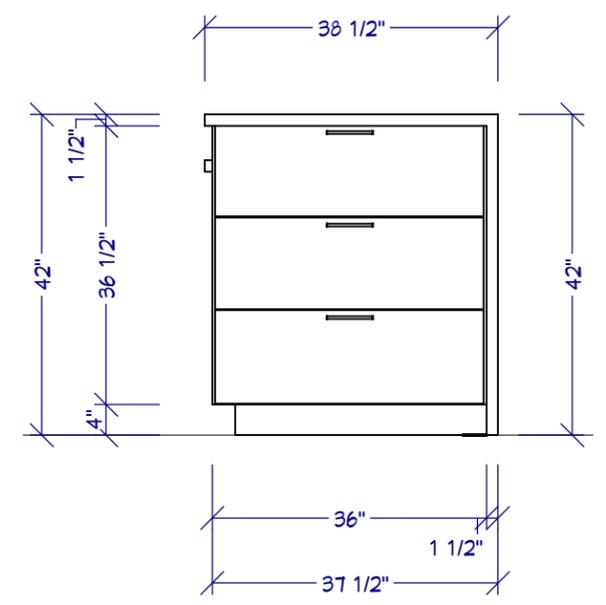

F ELEVATION F
1/2" = 1'



PERSPECTIVE WATERCOLOR
NO SCALE

DRAWINGS PROVIDED BY: ams
 Chief Architect Software
 chiefarchitect.com
 800.292.3400

DESIGNER:
 Davida Rodrigues
 Davida's Kitchen and Tiles


PROJECT DESCRIPTION:
 NKBA Study Guide:
 Small Kitchen

SHEET TITLE:
PERSPECTIVE

SCALE:
 SEE VIEW

DATE:
 7/14/2017

K-6

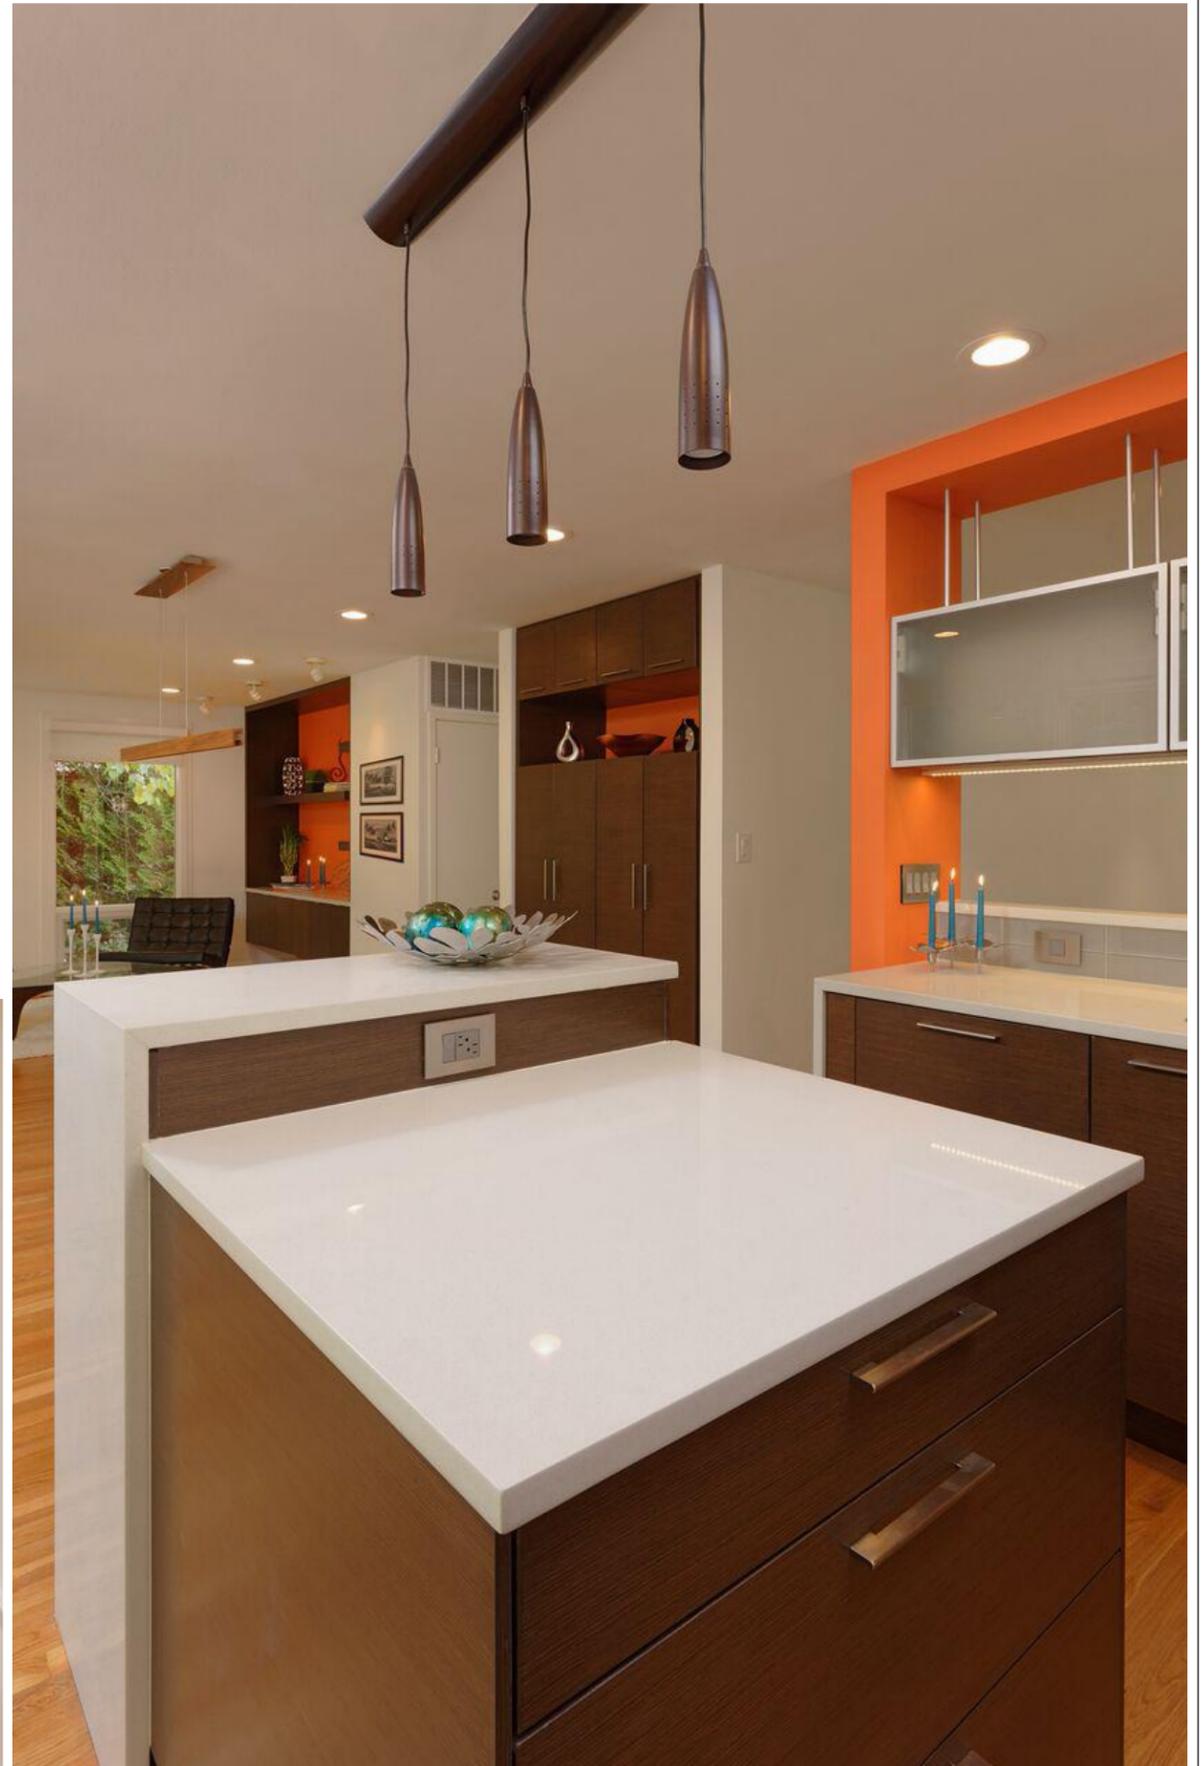

FINAL PHOTOGRAPHY
NO SCALE

DRAWINGS PROVIDED BY: ams
 Chief Architect Software
 chiefarchitect.com
 800.292.3400

DESIGNER:
 Davida Rodrigues
 Davida's Kitchen and Tiles

PROJECT DESCRIPTION:
 NKBA Study Guide:
 Small Kitchen

SHEET TITLE:
 FINAL PHOTOS

SCALE:
 SEE VIEW

DATE:
 7/14/2017

K-7